


-63¢ WP ___110ø SP 2 Toilet-1: Drainage Layout Scale: 1:20

Drawing and design are the property of Vastu Shilpa Consultants and are not to be copied or used without their permission.

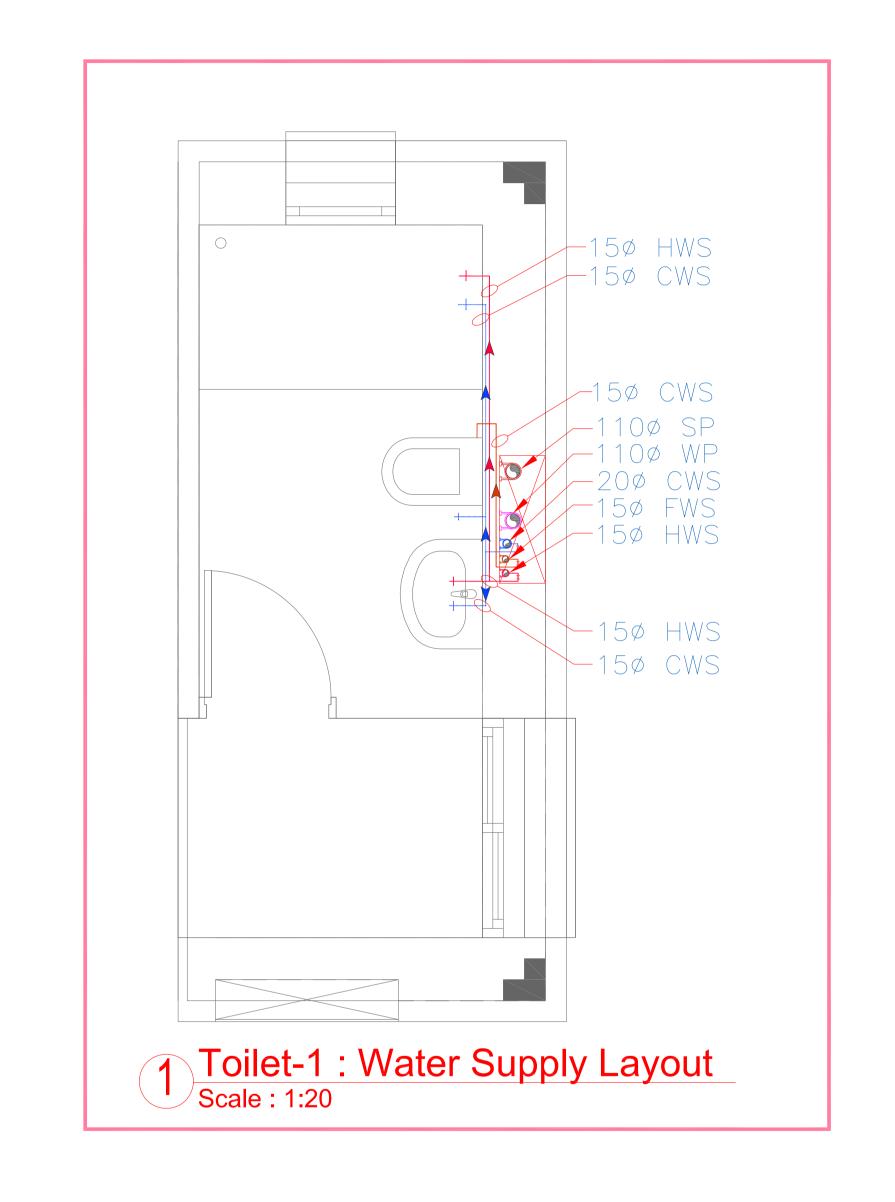

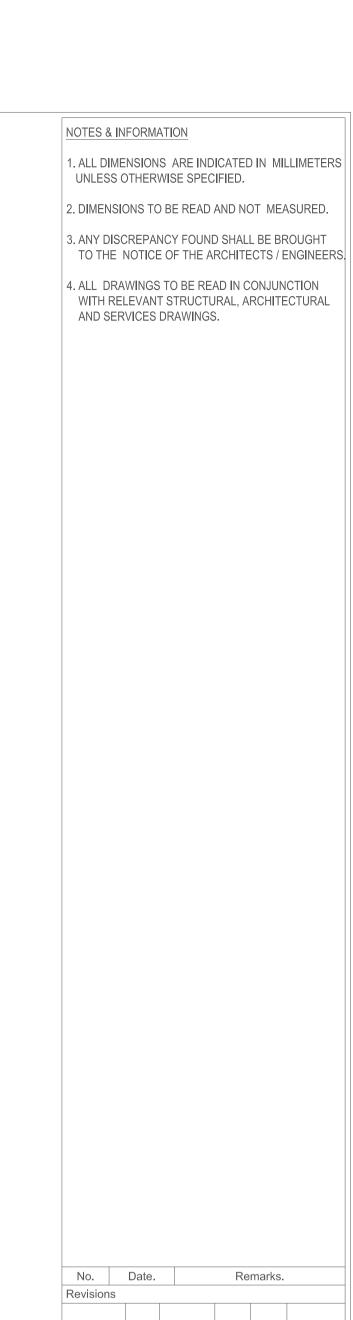

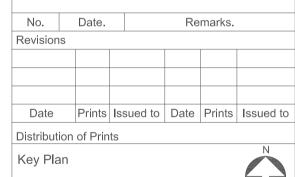

Consultants

Structural Consultants VR SHAH Consulting Engineers

Services Consultants



dbHMS
2nd Floor, D-62, Sector -2,
Noida - 201301
www.dbhms.in

Landscape Consultants Earthscapes Consultancy Pvt Ltd

Road and Pathways Consultants Arhmm Infra Consultants LLP

Nalanda University, Rajgir, Bihar

ENLARGE TOILET PLAN -PLUMBING FOR TENDER

Scale: 1:20

Drawing No. NUC(1)-FAH-T3-P3.1

Approved By: ∨M

VASTU SHILPA CONSULTANTS Architects I Planners I Urban Designers

'Sangath', Thaltej Road, Ahmedabad - 380054 Phone: 079 - 27454537 Fax: 079 - 27452006 www.sangath.org e-mail: vsc@sangath.org

