


LEGEND		
S.No	SYMBOL	DESCRIPTION
1.		9LTR WATER CO <sub>2</sub> FIRE EXTINGUISHER
2.		2KG DRY POWDER FIRE EXTINGUISHER
3.		FIRE HOSE REEL
4.		BUTTERFLY VALVE
5.		NON RETURN VALVE
6.		PRESSURE GAUGE
7.		Y-STRAINER

- NOTES**
1. ALL DIMENSIONS SHALL BE CHECKED AND CO-RELATED WITH THE STRUCTURAL DRAWINGS AND ANY AMBIGUITY SHALL BE IMMEDIATELY BROUGHT TO THE NOTICE OF THE ARCHITECT BEFORE COMMENCEMENT OF THE WORK.
  2. ALL DIMENSIONS ARE IN CENTIMETERS UNLESS AND OTHERWISE SPECIFIED
  3. ALL LEVELS ARE FINISHED LEVELS.
  4. ALL MARGINS, CLEARANCES ETC. REQUIRED AS PER BYE-LAWS SHOULD BE CHECKED AND PROVIDED BY THE CONTRACTOR AND ANY DISCREPANCIES FOUND SHOULD BE IMMEDIATELY BROUGHT TO THE NOTICE OF ARCHITECT BEFORE COMMENCEMENT OF WORK.
  5. FOR DETAILS OF ALL CUTOUTS IN SLABS AND BEAMS REFER SERVICES CONSULTANTS DRAWINGS.
  6. FOR STAIRCASE DETAILS REFER DRAWING NO. 5.1
  7. FOR TOILET DETAILS REFER DRAWING NO. 6.1
  8. FOR DOOR DETAILS REFER DRWG NO. 8.1
  9. FOR WINDOW DETAILS REFER DRWG NO. 9.1
  10. FOR KITCHEN - PANTRY DETAILS REFER DRWG NO. 10.1
  11. FOR MISCELLANEOUS DETAILS REFER DRAWING NO. 29.1
  12. FOR VERANDAH DETAILS REFER DRAWING NO. 31.1

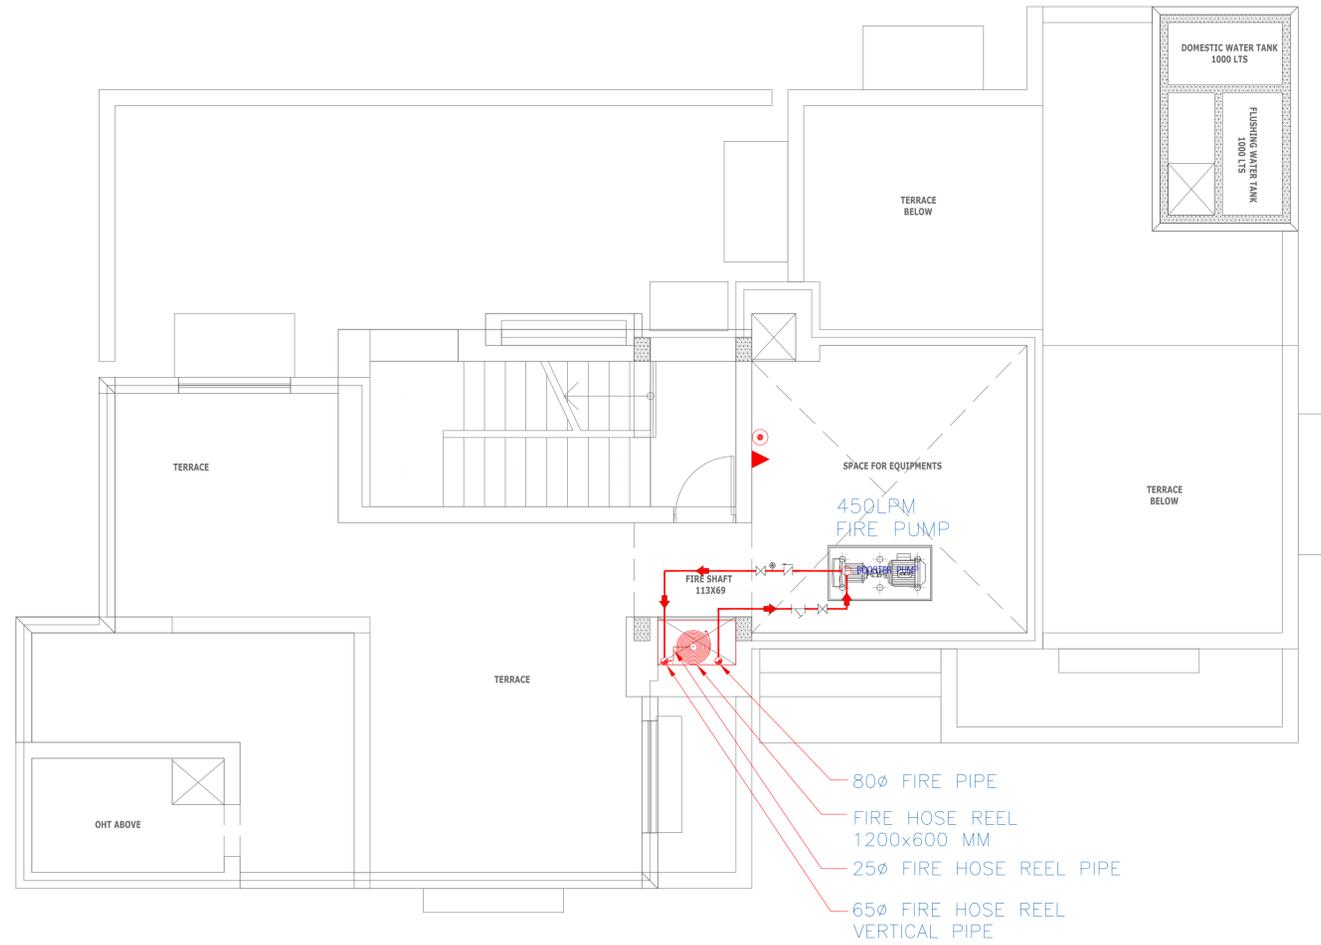

# 1 TERRACE FLOOR PLAN - FIRE FIGHTING

No.	Date.	Remarks.
Revisions		

Date	Prints	Issued to	Date	Prints	Issued to
Distribution of Prints					

Key Plan

- Consultants**
- Structural Consultants**  
VR SHAH Consulting Engineers
  - Services Consultants**  
 dbHMS  
2nd Floor, D-62, Sector -2,  
Noida - 201301  
www.dbhms.in
  - Landscape Consultants**  
Earthscaapes Consultancy Pvt Ltd
  - Road and Pathways Consultants**  
Arhmm Infra Consultants LLP

**Project**  
**Nalanda University, Rajgir, Bihar**

**Title**  
TERRACE FLOOR PLAN -  
FIRE FIGHTING  
FOR TENDER

Dealt : JK	Drawing No.
Checked : AT	NUC(1)-MSH-FF2.5
Scale : 1:50	Aprd By : VM
Date : 20.05.2016	

**VASTU SHILPA CONSULTANTS**  
Architects | Planners | Urban Designers

"Sangath", Thaltej Road, Ahmedabad - 380054  
Phone: 079 - 27454537 Fax: 079 - 27452006  
www.sangath.org e-mail: vsc@sangath.org