
Drawing and design are the property of Vastu Shilpa Consultants and are not to be copied or used without their permission.

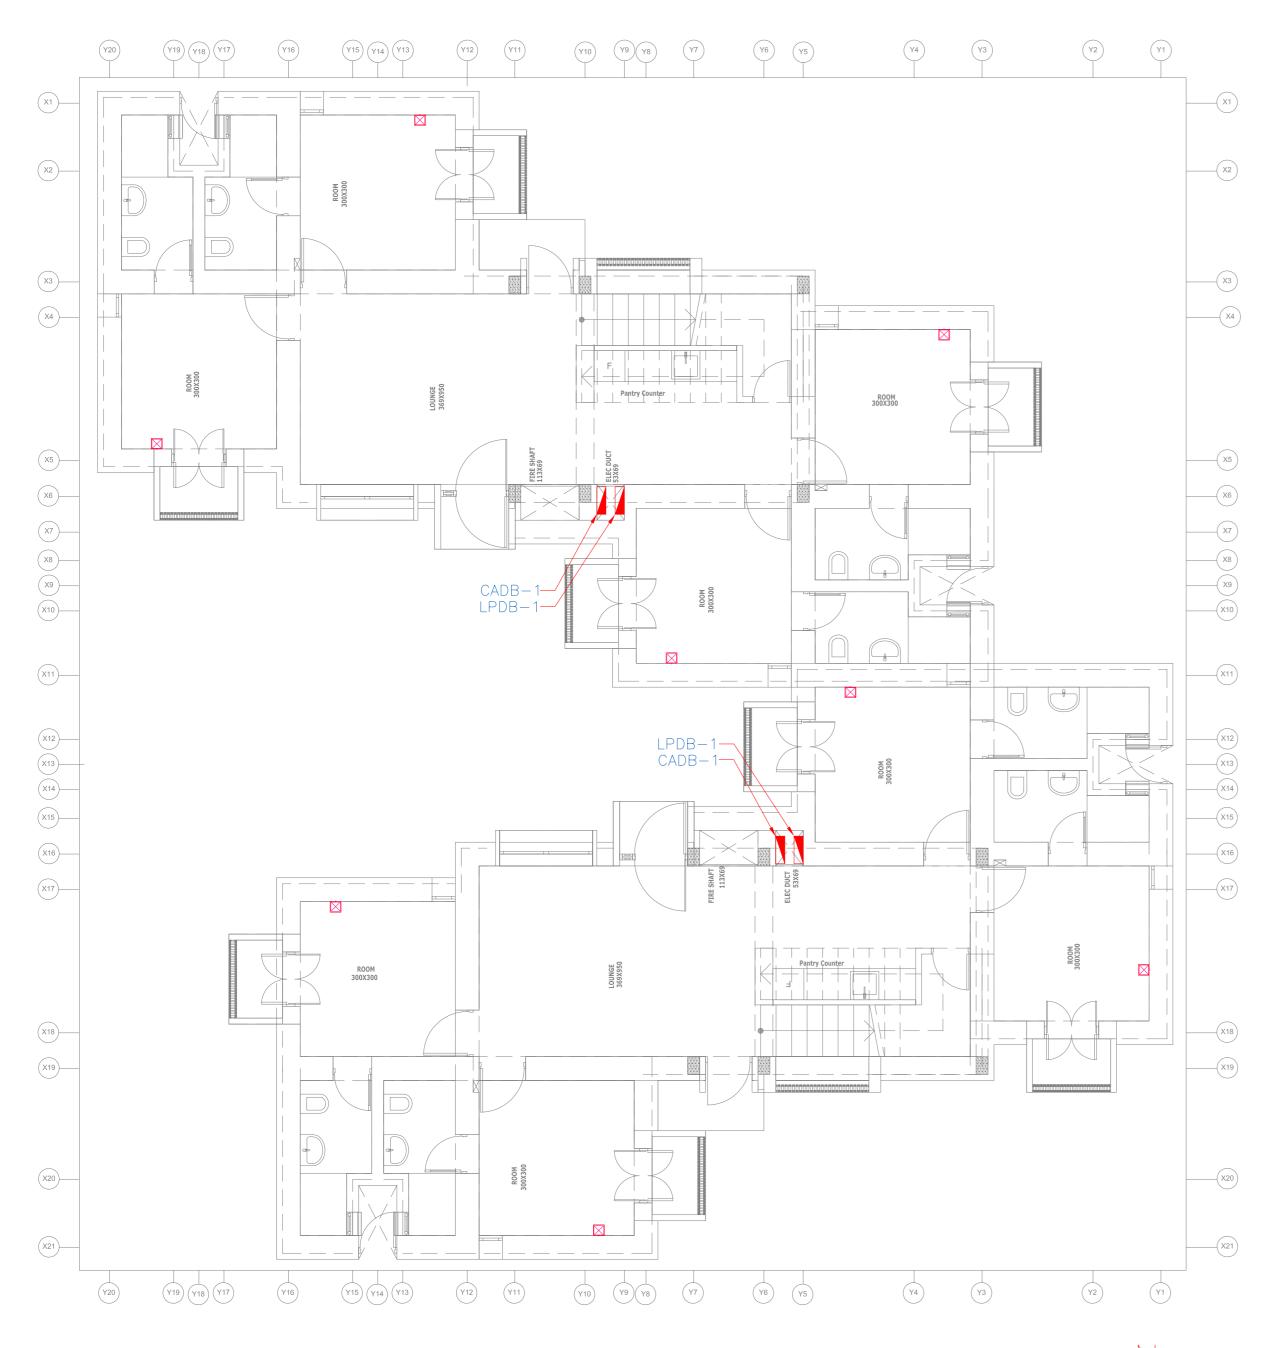

ELECTRICAL LEGEND:	
-\$-4	: 2600mm AFF AT KITCHEN WALL MOUNTED LIGHT FIXTURE: 2500mm AFF AT ENTRANCE FOYER : 2200mm AFF AT OTHER PLACES
+	14W. LED LIGHT FIXTURE
\circ	10W. LED LIGHT FIXTURE
	3W. LED MIRROR LIGHT FIXTURE
EX	EXHAUST FAN.
	OUTLET FOR CEILING FAN.
	LIFT LIGHT
	SINGLE POLE SWITCH FOR LIGHTING & FAN AT 1200mm SFL.
70	FAN REGULATOR AT 1200mm SFL.
<u> </u>	6A 3PIN SWITCHED SOCKET OUTLET.
	16A 6PIN SWITCHED SOCKET OUTLET.
	6/16A 6PIN SWITCH SOCKET OUTLET.
×	CONDUIT PROVISION FOR DATA WITH DUMMY PLATE AT 625mm SFL. IN ALL ROOMS
	DISTRIBUTION BOARD : 1600mm ABOVE SFL.

NOTES

1. ALL DIMENSIONS SHALL BE CHECKED WITH THE STRUCTURAL DRAWINGS AND SHALL BE IMMEDIATELY BROUGHT TO THARCHITECT BEFORE COMMENCEMENT O

SHALL BE IMMEDIATELY BROUGHT TO THE NOTICE OF TH ARCHITECT BEFORE COMMENCEMENT OF THE WORK. 2. ALL DIMENSIONS ARE IN CENTIMETERS UNLESS AND OTHERWISE SPECIFIED

ALL DIMENSIONS ARE IN CENTIMETERS
 OTHERWISE SPECIFIED

3. ALL LEVELS ARE FINISHED LEVELS.

ALL MARGINS, CLEARENCES ETC. REQUIRED AS PERFECT AND SHOULD BE CHECKED AND PROVIDED BY TOORTH ACTOR AND ANY DESCRIPENCIES FOUND SHOULD BE IMMIDIATELY BROUGHT TO THE NOTICE OF ARCHIT

5. FOR DETAILS OF ALL CUTOUTS IN SLABS AND BEAMS REFER SERVICES CONSULTANTS DRAWINGS.

7. FOR TOILET DETAILS REFER DRAWING, NO. 6.1

FOR TOILET DETAILS REFER DRAWING. NO.
 FOR DOOR DETAILS REFER DRWG NO. 8.1

FOR WINDOW DETAILS REFER DRWG NO. 8.1

9. FOR WINDOW DETAILS REFER DRWG NO. 9.1

10. FOR KITCHEN - PANTRY DETAILS REFER DRWG NO. 10.1

11. FOR MISCELLANEOUS DETAILS REFER DRAWING NO. 29.112. FOR VERANDAH DETAILS REFER DRAWING NO. 31.1

No. Date. Remarks.

Revisions

Date Prints Issued to Date Prints Issued to

Distribution of Prints

Key Plan



Consultants

O Structural Consultants
VR SHAH Consulting Engineers

Services Consultants



2nd Floor, D-62, Sector -2, Noida - 201301 www.dbhms.in

○ Landscape Consultants
Earthscapes Consultancy Pvt Ltd

O Road and Pathways Consultants
Arhmm Infra Consultants LLP

Project

Nalanda University, Rajgir, Bihar

Tit

GROUND FLOOR PLAN — ELV LAYOUT

Dealt: V.K.
Checked: M.T.
Scale: 1:50
Date: 06.06.2016

FOR TENDER

Drawing No.
NUC(1)-RSH-E2.1.3

Aprd By: V.M.

VASTU SHILPA CONSULTANTS Architects I Planners I Urban Designers

'Sangath', Thaltej Road, Ahmedabad - 380054 Phone: 079 - 27454537 Fax: 079 - 27452006 www.sangath.org e-mail: vsc@sangath.org

