
Prawing and design are the property of Vastu Shilpa Consultants and are not to be copied or used without their permission.

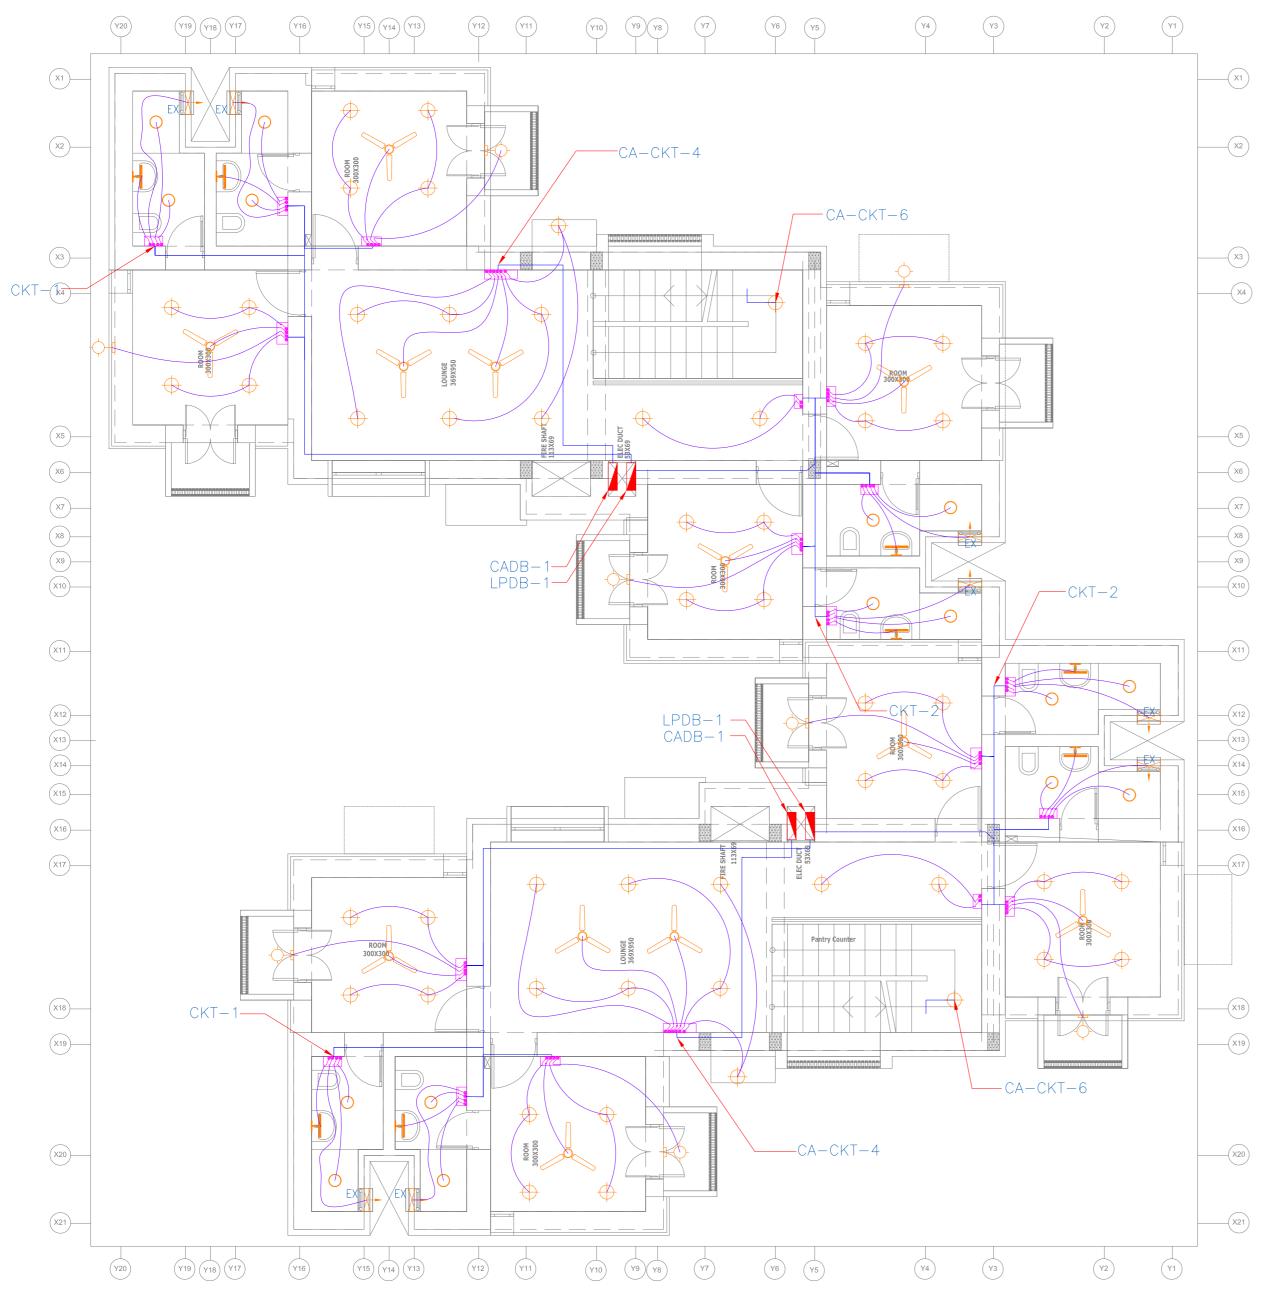

		ELECTRICAL LEGEND:
X1)	-	: 2600mm AFF AT KITCHEN WALL MOUNTED LIGHT FIXTURE: 2500mm AFF AT ENTRANCE FOYER : 2200mm AFF AT OTHER PLACES
	\oplus	14W. LED LIGHT FIXTURE
X2	0	10W. LED LIGHT FIXTURE
	T	3W. LED MIRROR LIGHT FIXTURE
	₩ EX	EXHAUST FAN.
X3 X4		OUTLET FOR CEILING FAN.
	~	LIFT LIGHT
		SINGLE POLE SWITCH FOR LIGHTING & FAN AT 1200mm SFL.
	TO .	FAN REGULATOR AT 1200mm SFL.
X5)	Ļ	6A 3PIN SWITCHED SOCKET OUTLET.
X6 X7	<u></u>	16A 6PIN SWITCHED SOCKET OUTLET.
X8)		6/16A 6PIN SWITCH SOCKET OUTLET.
X8 X9 (10)	Ķ	CONDUIT PROVISION FOR DATA WITH DUMMY PLATE AT 625mm SFL. IN ALL ROOMS
		DIOTRIBUTION DOLDS 4000 ADOLE OF

DISTRIBUTION BOARD: 1600mm ABOVE SFL.

NOTES

2. ALL DIMENSIONS ARE IN CENTIMETERS UNLESS AND OTHERWISE SPECIFIED

3. ALL LEVELS ARE FINISHED LEVELS.

5. FOR DETAILS OF ALL CUTOUTS IN SLABS AND BEAMS REFER SERVICES CONSULTANTS DRAWINGS.

6. FOR STAIRCASE DETAILS REFER DRAWING, NO. 5.1 7. FOR TOILET DETAILS REFER DRAWING, NO. 6.1

8. FOR DOOR DETAILS REFER DRWG NO. 8.1

9. FOR WINDOW DETAILS REFER DRWG NO. 9.1 10. FOR KITCHEN - PANTRY DETAILS REFER DRWG NO. 10.1

11. FOR MISCELLANEOUS DETAILS REFER DRAWING NO. 29.1 12. FOR VERANDAH DETAILS REFER DRAWING NO. 31.1

No. Date. Remarks.

Date Prints Issued to Date Prints Issued to

Distribution of Prints

Key Plan



Consultants

○ Structural Consultants

VR SHAH Consulting Engineers Services Consultants



2nd Floor, D-62, Sector -2, Noida - 201301 www.dbhms.in

○ Landscape Consultants Earthscapes Consultancy Pvt Ltd

Road and Pathways Consultants Arhmm Infra Consultants LLP

Nalanda University, Rajgir, Bihar

FIRST FLOOR PLAN - LIGHTING LAYOUT FOR TENDER

> Dealt : Drawing No. V.K. Checked : M.T. NUC(1)-RSH-E2.2.2 Scale : 1:50 Aprd By: V.M. Date :

06.06.2016 VASTU SHILPA CONSULTANTS Architects I Planners I Urban Designers

'Sangath', Thaltej Road, Ahmedabad - 380054 Phone: 079 - 27454537 Fax: 079 - 27452006 www.sangath.org e-mail: vsc@sangath.org

2 FIRST FLOOR PLAN - LIGHTING LAYOUT